


DRAWINGS NOTES:

1. ALL CIRCUITS ARE TO BE IN GALVANISED TRUNKING & METAL CONDUIT. CONTRACTOR TO PROVIDE AS REQUIRED.
2. CONTRACTOR TO PROVIDE AN ELECTRICAL INSTALLATIONS COMPLETION CERTIFICATE FOR ALL ELECTRICAL WORKS.
3. ALL SERVICES AS PER DRAWING TO BE INSTALLED BY CONTRACTOR, DATA & POWER TO BE IN SEPARATE CONTAINMENT AT ALL TIMES. LSF CABLE TO BE RUN IN CONDUITS FROM TRUNKING INSTALLED ON CEILING SLAB BELOW. ALL FIRE ALARM, DATA, ACCESS CONTROLS & SUB CIRCUITS TO BE RUN IN STEEL CONDUITS FROM TRAY & TRUNKING.
4. ALL CONDUITS TO BE RECESSED/FLUSH.
5. ELECTRICAL CONTRACTOR TO ALLOW FOR CONNECTING OF DISTRIBUTION BOARD HEADER INTO MAIN TRUNKING RISER.
6. THIS DRAWING INCLUDES DETAILS OF PRIMARY CONTAINMENT ONLY. THE CONTRACTOR SHALL ALLOW FOR ALL SECONDARY CONTAINMENT AND CONDUITS NOT SHOWN ON THIS DRAWING.


LEGEND OF SYMBOLS:

- L&P TRUNKING - 50x50mm
UNLESS OTHERWISE NOTED
- ELV CABLE BASKET - 150x25mm
UNLESS OTHERWISE NOTED
- FA CABLE TRAY - 50x25mm
UNLESS OTHERWISE NOTED

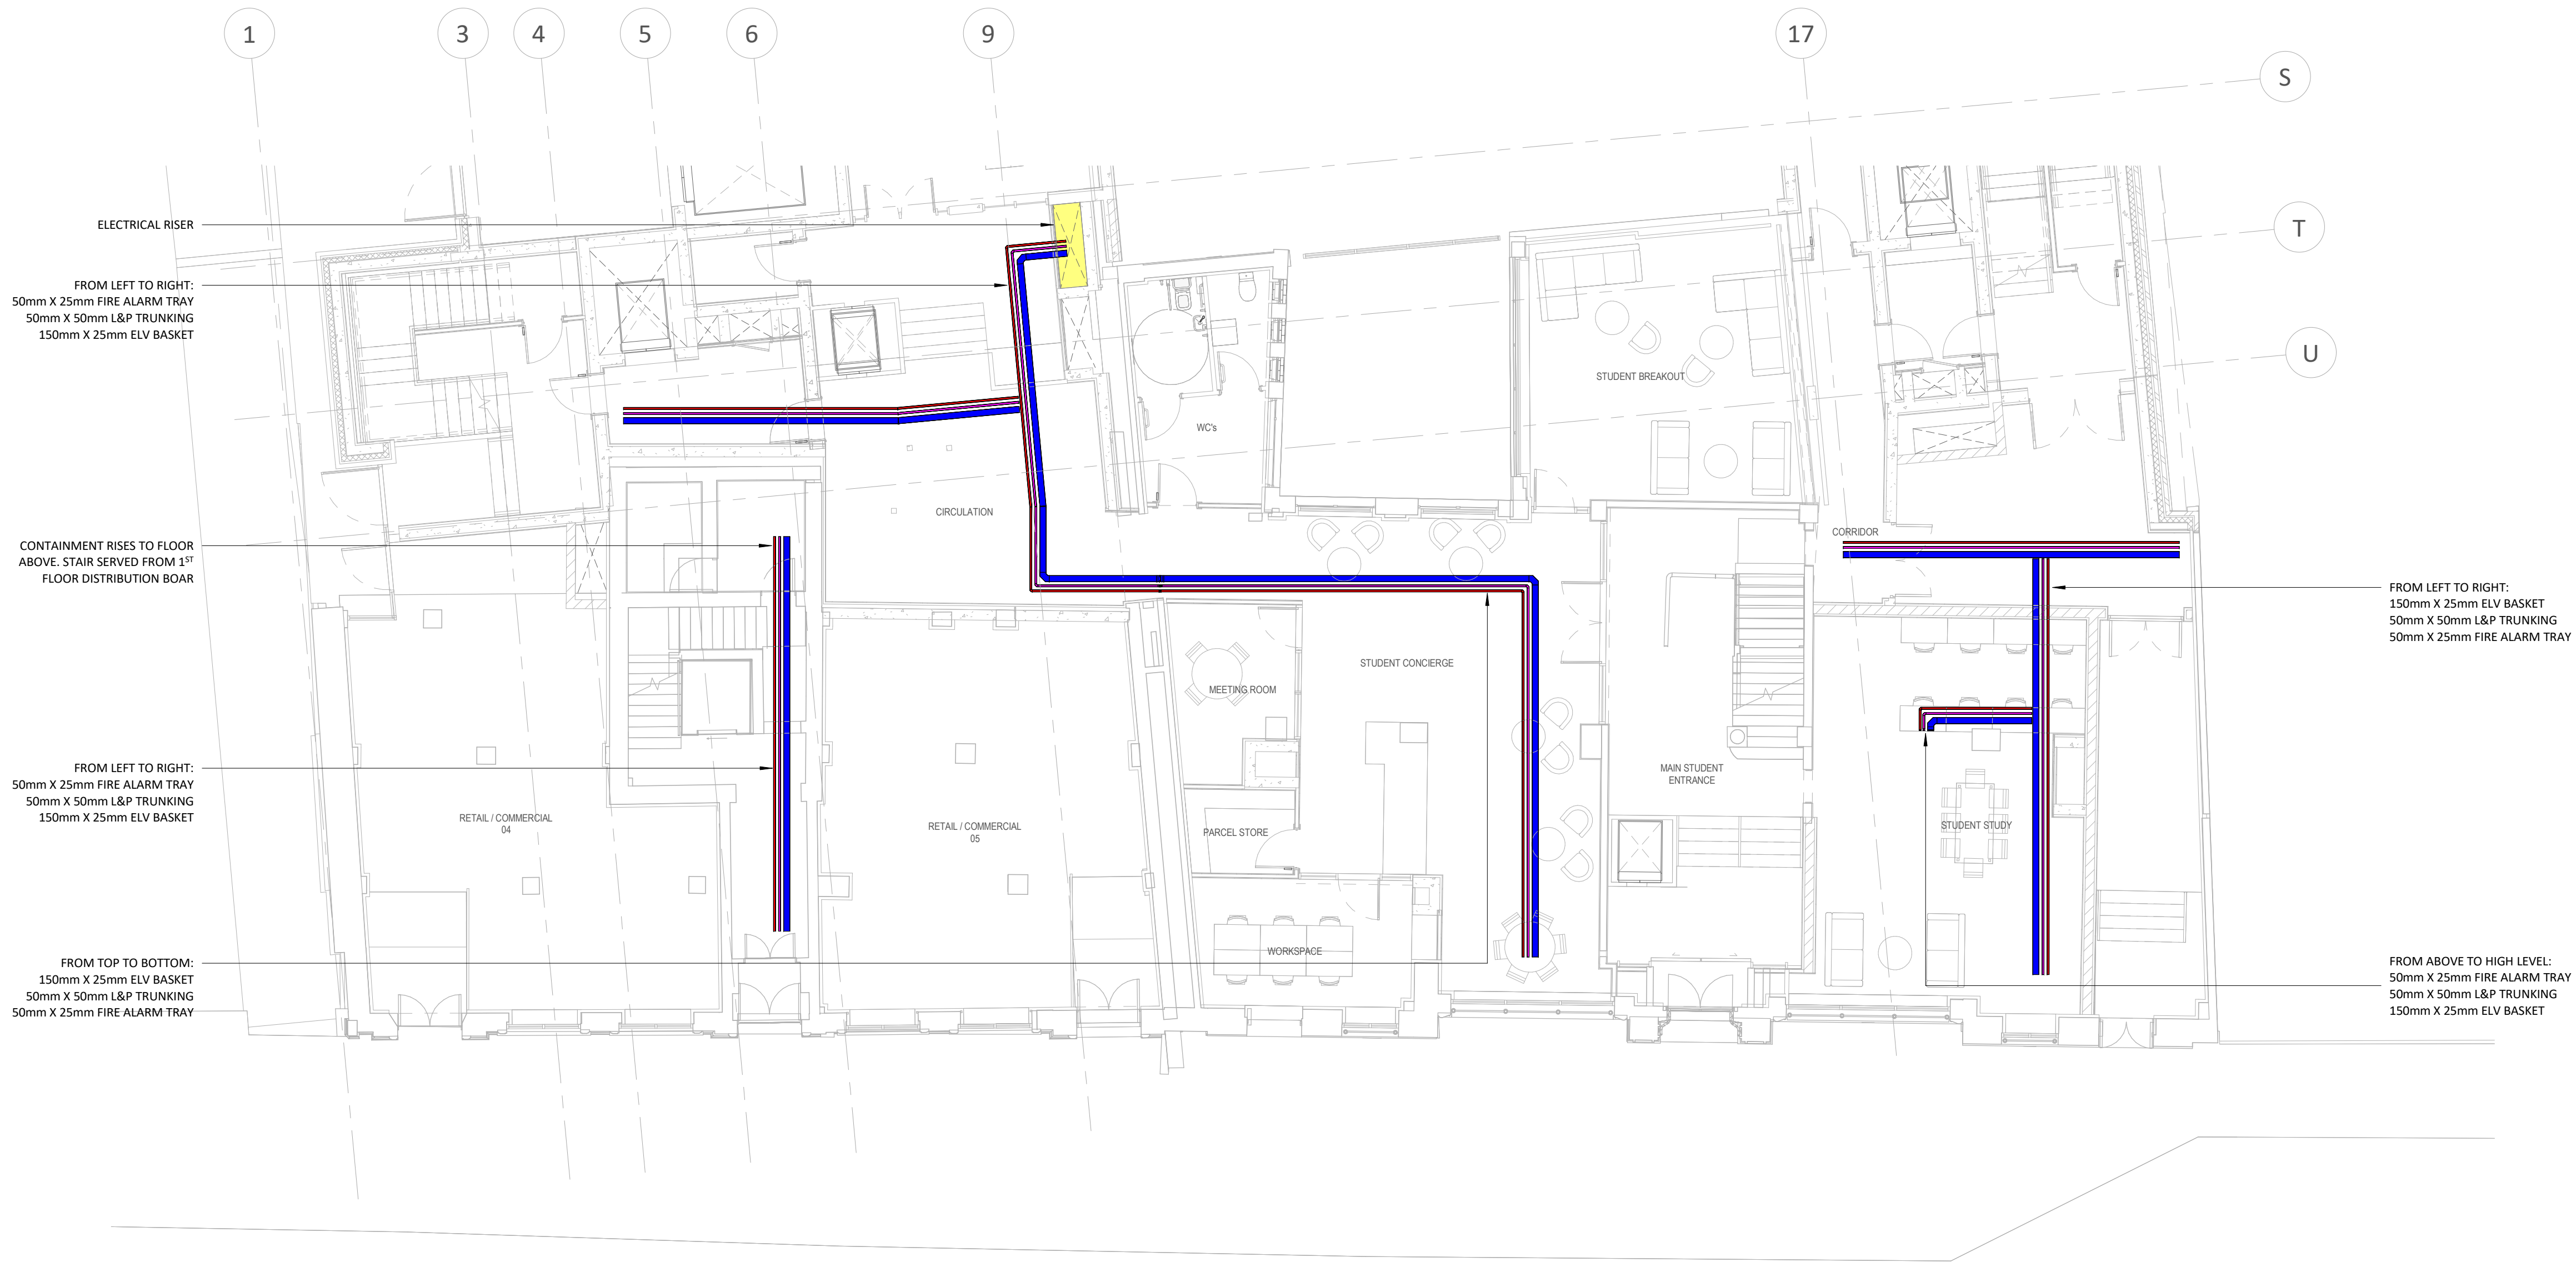

FROM LEFT TO RIGHT:
150mm X 25mm ELV BASKET
50mm X 50mm L&P TRUNKING
50mm X 25mm FIRE ALARM TRAY

FROM ABOVE TO HIGH LEVEL:
50mm X 25mm FIRE ALARM TRAY
50mm X 50mm L&P TRUNKING
150mm X 25mm ELV BASKET

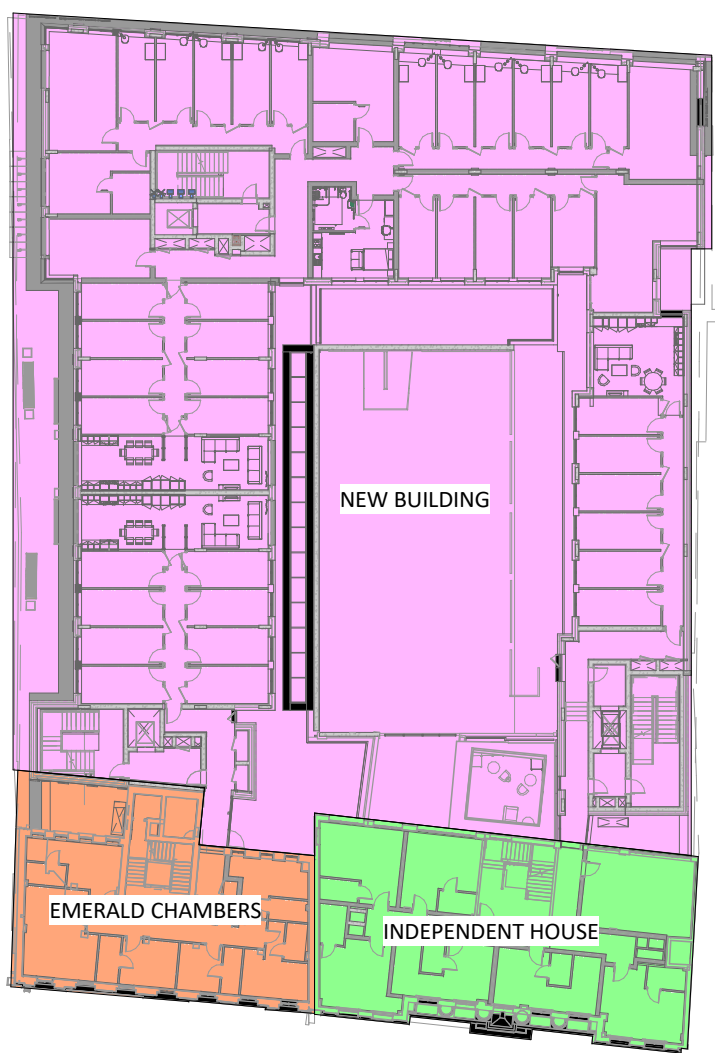

KEYPLAN
N.T.S.

00 - GROUND FLOOR EMERALD CHAMBERS & INDEPENDENT HOUSE - CONTAINMENT
1 : 100

- FOR SETTING OUT REFER TO ARCHITECT'S DRAWINGS.
- THIS DRAWING TO BE READ IN CONJUNCTION WITH ALL OTHER ARCHITECTURAL AND ENGINEERING DRAWINGS AND ALL OTHER RELEVANT DRAWINGS AND SPECIFICATIONS.
- DO NOT SCALE THIS DRAWING. USE FIGURED DIMENSIONS ONLY.
- NO PART OF THIS DOCUMENT MAY BE REPRODUCED OR TRANSMITTED IN ANY FORM OR STORED IN ANY RETRIEVAL SYSTEM OF ANY NATURE WITHOUT THE WRITTEN PERMISSION OF O'CONNOR SUTTON CRONIN AS COPYRIGHT HOLDER EXCEPT AS AGREED FOR USE ON THE PROJECT FOR WHICH THE DOCUMENT WAS ORIGINALLY ISSUED.

Rev No.	Date	Revision Note	Drn by	Chkd by
P01	20.02.25	SUITABLE FOR INFORMATION	T.S.	B.F.



OCSC
O'CONNOR • SUTTON • CRONIN
MULTIDISCIPLINARY CONSULTING ENGINEERS

Civil / Structural / Environmental / Mechanical / Electrical / Sustainability
Dublin Office: 9 Prussia Street, Dublin 7, D07 KT57.

Tel: +353 (0)1 8682000 Web: www.ocsc.ie
Dublin • London • Belfast • Galway • Cork • Birmingham

Client: SUMMIX IHD DEVELOPMENTS LIMITED
Project: INDEPENDENT HOUSE STUDENT ACCOMMODATION
90 MIDDLE ABBEY ST., DUBLIN 1, IRELAND

Title: ELECTRICAL
POWER CONTAINMENT SERVICES LAYOUT
GROUND FLOOR PLAN



Code | Originator | Zone | Level | Type | Role | Number | Status | Revision
IHS - OCSC - XX - GF - DR - E - 6001 | SO | P01
Date: 13.02.25 Scale: As indicated @ A1 Drn by: TS Chkd by: BF Aprvd by: BF

DRAWINGS NOTES:

1. ALL CIRCUITS ARE TO BE IN GALVANISED TRUNKING & METAL CONDUIT. CONTRACTOR TO PROVIDE AS REQUIRED.
2. CONTRACTOR TO PROVIDE AN ELECTRICAL INSTALLATIONS COMPLETION CERTIFICATE FOR ALL ELECTRICAL WORKS.
3. ALL SERVICES AS PER DRAWING TO BE INSTALLED BY CONTRACTOR, DATA & POWER TO BE IN SEPARATE CONTAINMENT AT ALL TIMES. LSF CABLE TO BE RUN IN CONDUITS FROM TRUNKING INSTALLED ON CEILING SLAB BELOW. ALL FIRE ALARM, DATA, ACCESS CONTROLS & SUB CIRCUITS TO BE RUN IN STEEL CONDUITS FROM TRAY & TRUNKING.
4. ALL CONDUITS TO BE RECESSED/FLUSH.
5. ELECTRICAL CONTRACTOR TO ALLOW FOR CONNECTING OF DISTRIBUTION BOARD HEADER INTO MAIN TRUNKING RISER.
6. THIS DRAWING INCLUDES DETAILS OF PRIMARY CONTAINMENT ONLY. THE CONTRACTOR SHALL ALLOW FOR ALL SECONDARY CONTAINMENT AND CONDUITS NOT SHOWN ON THIS DRAWING.

LEGEND OF SYMBOLS:

- L&P TRUNKING - 50x50mm
UNLESS OTHERWISE NOTED
- ELV CABLE BASKET - 150x25mm
UNLESS OTHERWISE NOTED
- FA CABLE TRAY - 50x25mm
UNLESS OTHERWISE NOTED

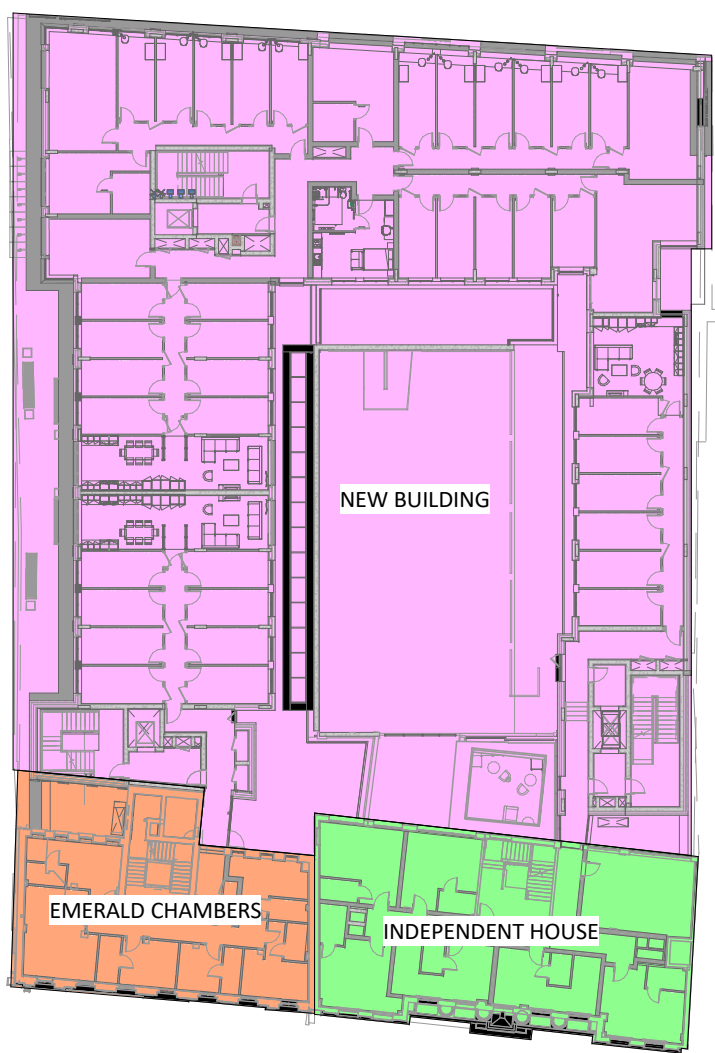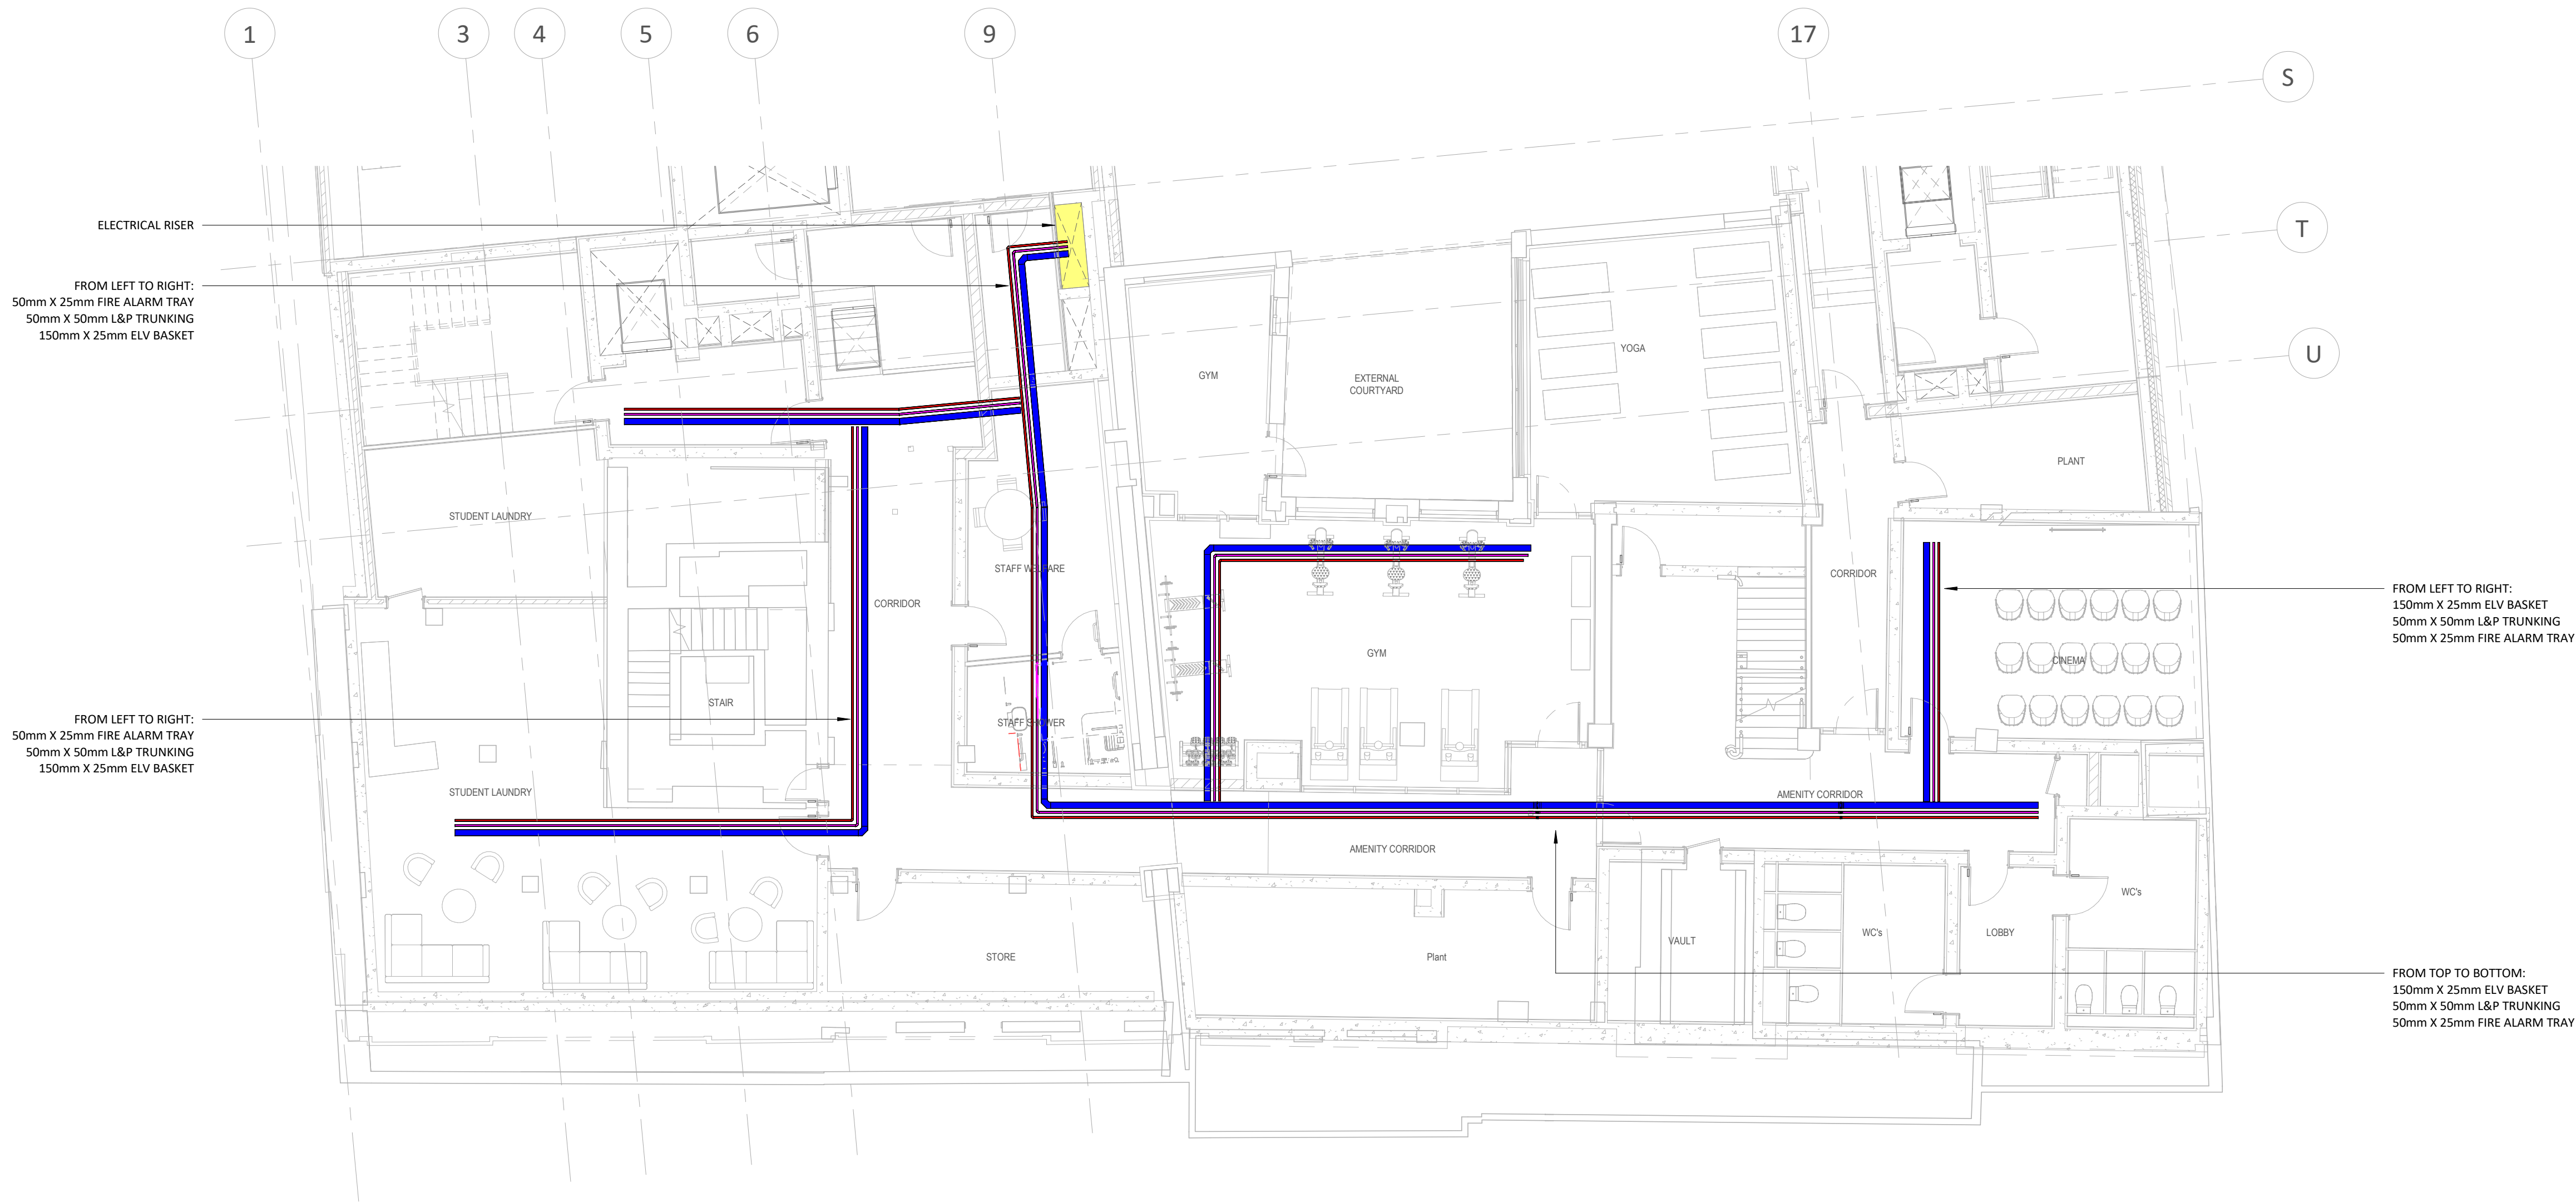

KEYPLAN
N.T.S.

B1 - BASEMENT EMERALD CHAMBERS & INDEPENDENT HOUSE - CONTAINMENT
1 : 100

- FOR SETTING OUT REFER TO ARCHITECT'S DRAWINGS.
- THIS DRAWING TO BE READ IN CONJUNCTION WITH ALL OTHER ARCHITECTURAL AND ENGINEERING DRAWINGS AND ALL OTHER RELEVANT DRAWINGS AND SPECIFICATIONS.
- DO NOT SCALE THIS DRAWING. USE FIGURED DIMENSIONS ONLY.
- NO PART OF THIS DOCUMENT MAY BE REPRODUCED OR TRANSMITTED IN ANY FORM OR STORED IN ANY RETRIEVAL SYSTEM OF ANY NATURE WITHOUT THE WRITTEN PERMISSION OF O'CONNOR SUTTON CRONIN AS COPYRIGHT HOLDER EXCEPT AS AGREED FOR USE ON THE PROJECT FOR WHICH THE DOCUMENT WAS ORIGINALLY ISSUED.

Rev No.	Date	Revision Note	Drn by	Chkd by
P01	20.02.25	SUITABLE FOR INFORMATION	T.S.	B.F.



OCSC
O'CONNOR • SUTTON • CRONIN
MULTIDISCIPLINARY CONSULTING ENGINEERS


Civil / Structural / Environmental / Mechanical / Electrical / Sustainability
Dublin Office: 9 Prussia Street, Dublin 7, D07 KT57.

Tel: +353 (0)1 8682000 Web: www.ocsc.ie
Dublin • London • Belfast • Galway • Cork • Birmingham


Client: SUMMIX IHD DEVELOPMENTS LIMITED
Project: INDEPENDENT HOUSE STUDENT ACCOMMODATION
90 MIDDLE ABBEY ST., DUBLIN 1, IRELAND

Title: ELECTRICAL
POWER CONTAINMENT SERVICES LAYOUT
BASEMENT FLOOR PLAN

Code | Originator | Zone | Level | Type | Role | Number | Status | Revision
IHS - OCSC - XX - B1 - DR - E - 6000. S0 P01
Date: 13.02.25 Scale: As indicated @ A1 Drn by: TS Chkd by: BF Aprvd by: BF

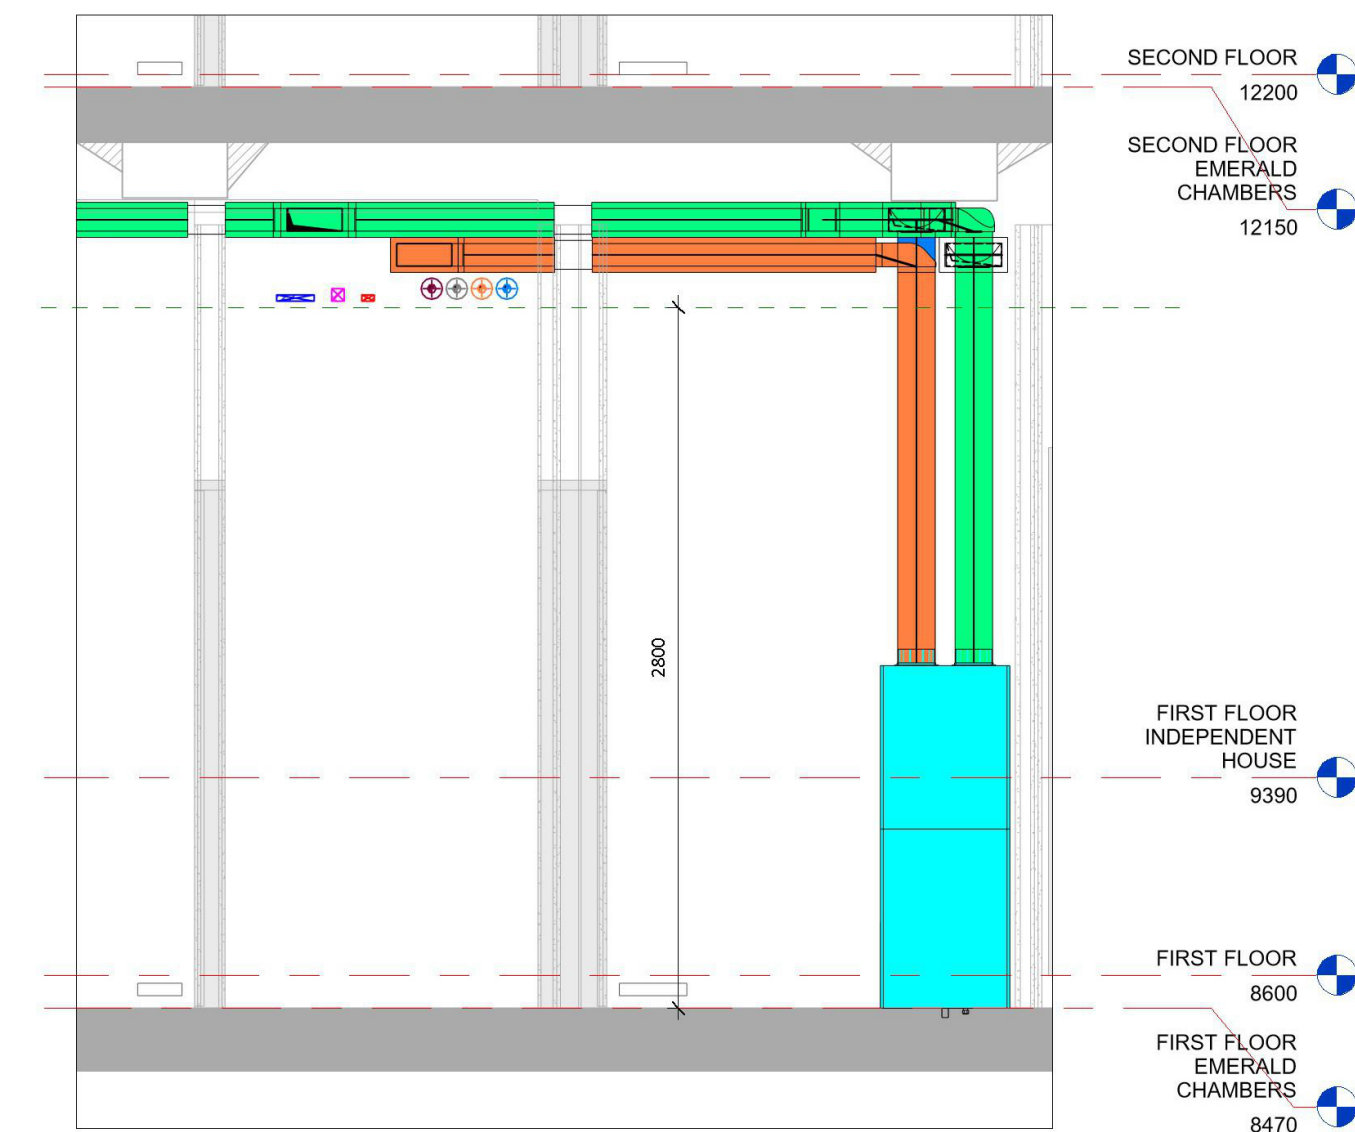

FIRST FLOOR CORRIDOR SECTION DETAIL - EMERALD CHAMBERS
1 : 50

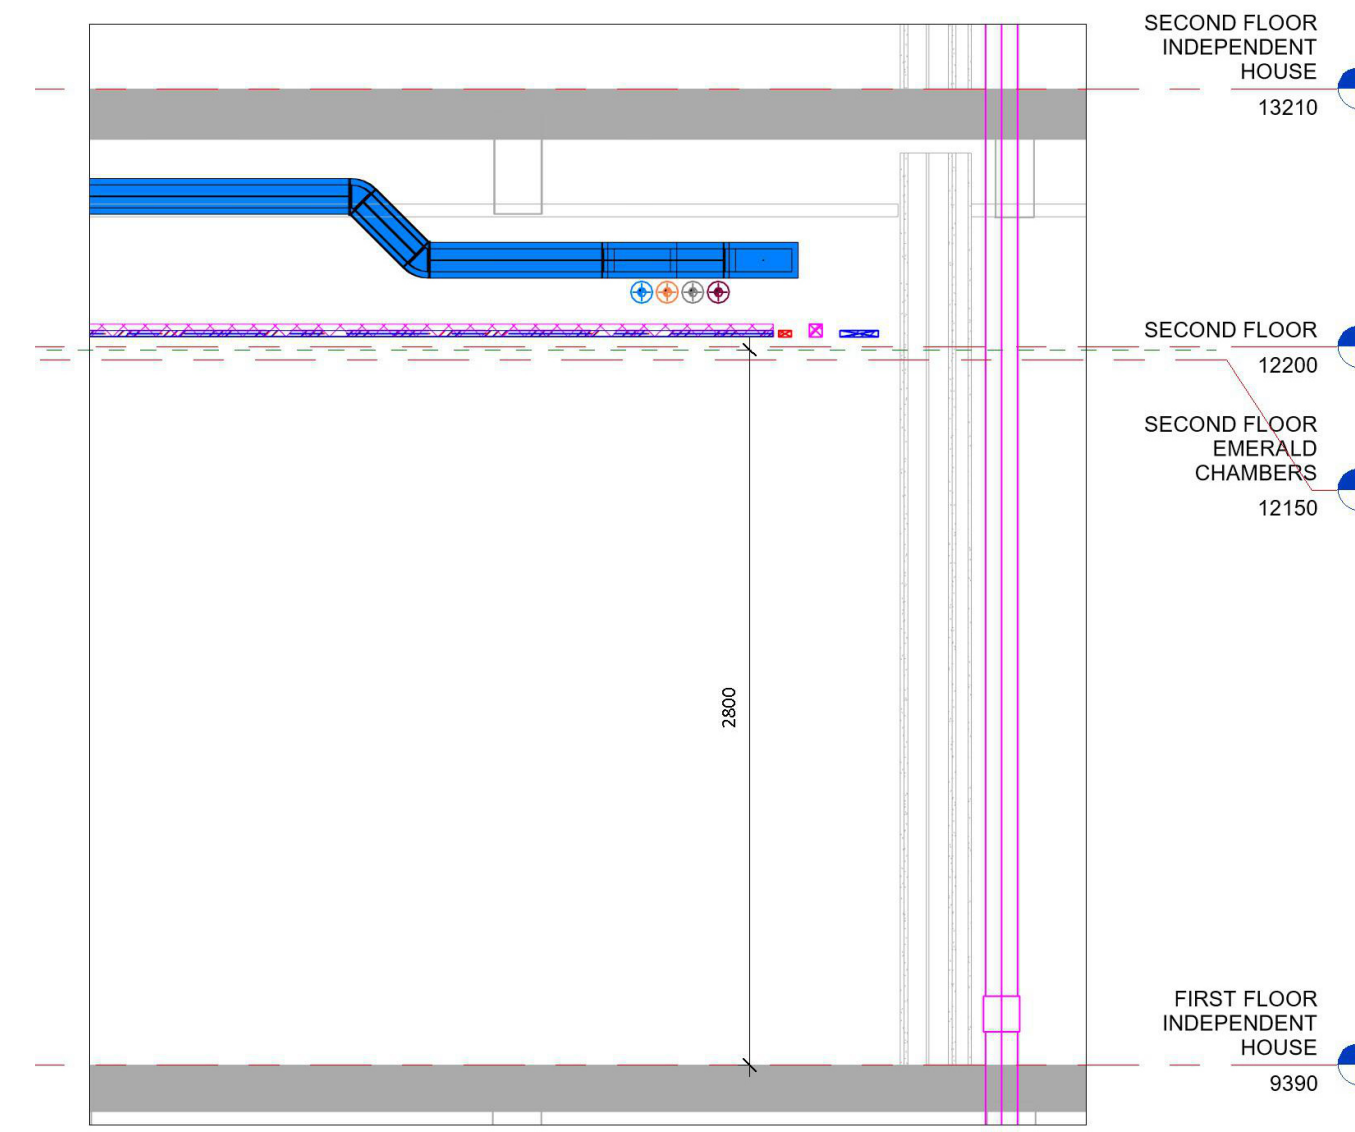

FIRST FLOOR CORRIDOR SECTION DETAIL - INDEPENDENT HOUSE
1 : 50

DRAWINGS NOTES:


1. ALL CIRCUITS ARE TO BE IN GALVANISED TRUNKING & METAL CONDUIT. CONTRACTOR TO PROVIDE AS REQUIRED.
2. CONTRACTOR TO PROVIDE AN ELECTRICAL INSTALLATIONS COMPLETION CERTIFICATE FOR ALL ELECTRICAL WORKS.
3. ALL SERVICES AS PER DRAWING TO BE INSTALLED BY CONTRACTOR, DATA & POWER TO BE IN SEPARATE CONTAINMENT AT ALL TIMES. LSF CABLE TO BE RUN IN CONDUITS FROM TRUNKING INSTALLED ON CEILING SLAB BELOW. ALL FIRE ALARM, DATA, ACCESS CONTROLS & SUB CIRCUITS TO BE RUN IN STEEL CONDUITS FROM TRAY & TRUNKING.
4. ALL CONDUITS TO BE RECESSED/FLUSH.
5. ELECTRICAL CONTRACTOR TO ALLOW FOR CONNECTING OF DISTRIBUTION BOARD HEADER INTO MAIN TRUNKING RISER.
6. THIS DRAWING INCLUDES DETAILS OF PRIMARY CONTAINMENT ONLY. THE CONTRACTOR SHALL ALLOW FOR ALL SECONDARY CONTAINMENT AND CONDUITS NOT SHOWN ON THIS DRAWING.

LEGEND OF SYMBOLS:

- L&P TRUNKING - 50x50mm
UNLESS OTHERWISE NOTED
- ELV CABLE BASKET - 150x25mm
UNLESS OTHERWISE NOTED
- FA CABLE TRAY - 50x25mm
UNLESS OTHERWISE NOTED



01 - FIRST FLOOR EMERALD CHAMBERS & INDEPENDENT HOUSE - CONTAINMENT
1 : 100

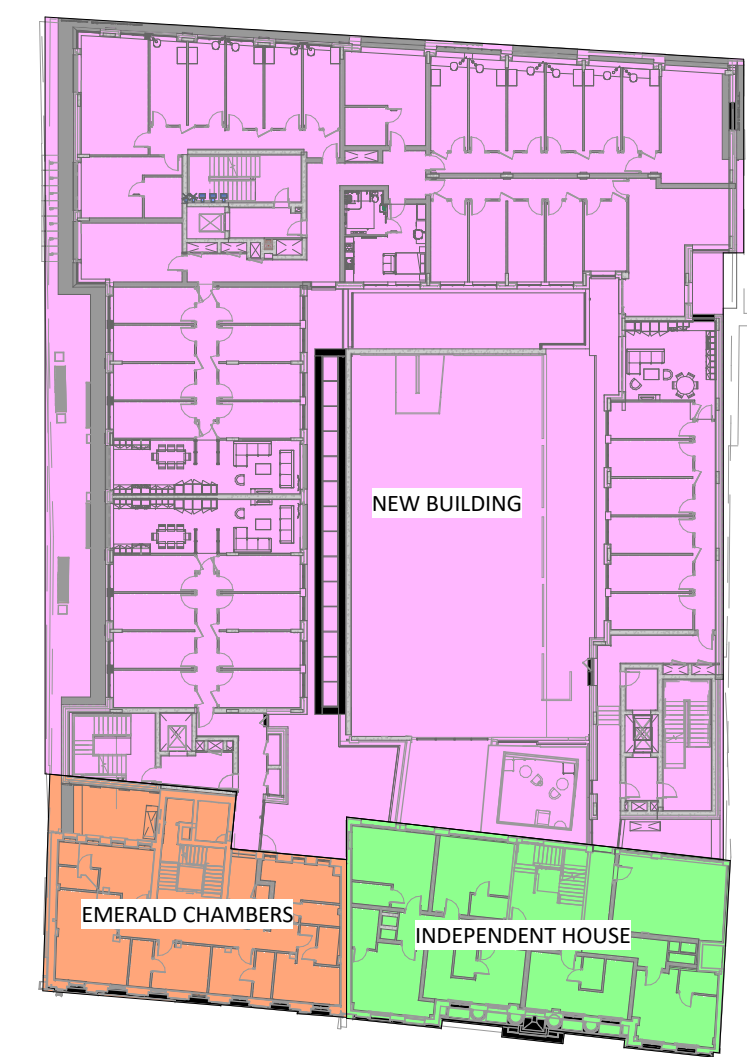

KEYPLAN
N.T.S.

- FOR SETTING OUT REFER TO ARCHITECT'S DRAWINGS.
- THIS DRAWING TO BE READ IN CONJUNCTION WITH ALL OTHER ARCHITECTURAL AND ENGINEERING DRAWINGS AND ALL OTHER RELEVANT DRAWINGS AND SPECIFICATIONS.
- DO NOT SCALE THIS DRAWING. USE FIGURED DIMENSIONS ONLY.
- NO PART OF THIS DOCUMENT MAY BE REPRODUCED OR TRANSMITTED IN ANY FORM OR STORED IN ANY RETRIEVAL SYSTEM OF ANY NATURE WITHOUT THE WRITTEN PERMISSION OF O'CONNOR SUTTON CRONIN AS COPYRIGHT HOLDER EXCEPT AS AGREED FOR USE ON THE PROJECT FOR WHICH THE DOCUMENT WAS ORIGINALLY ISSUED.

Rev No.	Date	Revision Note	Drn by	Chkd by
P01	20.02.25	SUITABLE FOR INFORMATION	T.S.	B.F.



OCSC
O'CONNOR • SUTTON • CRONIN
MULTIDISCIPLINARY CONSULTING ENGINEERS

Civil / Structural / Environmental / Mechanical / Electrical / Sustainability

Dublin Office: 9 Prussia Street, Dublin 7, D07 KT57.

Tel: +353 (0)1 8682000

Web: www.ocsc.ie

Dublin • London • Belfast • Galway • Cork • Birmingham

Client: SUMMIX IHD DEVELOPMENTS LIMITED
Project: INDEPENDENT HOUSE STUDENT ACCOMMODATION
90 MIDDLE ABBEY ST., DUBLIN 1, IRELAND

Title: ELECTRICAL
POWER CONTAINMENT SERVICES LAYOUT
FIRST FLOOR PLAN

Code	Originator	Zone	Level	Type	Role	Number	Status	Revision	
IHS	-	OCSC	-	XX	-	01	-	DR - E - 6002	S0 P01

Date: 13.02.25 Scale: As indicated @ A1 Drn by: TS Chkd by: BF Aprvd by: BF